

project:
CEDAR LANE RESIDENCE

client:
OKAFOR FAMILY

location:
BOULDER, COLORADO

Project No. 2020-031

REFLECTED CEILING /

LIGHTING PLANS

key plan

issued:

revision:

drawn:

TBM

checked:


F.S.

scale:

1/4"=1'-0"

sheet:

E2.00

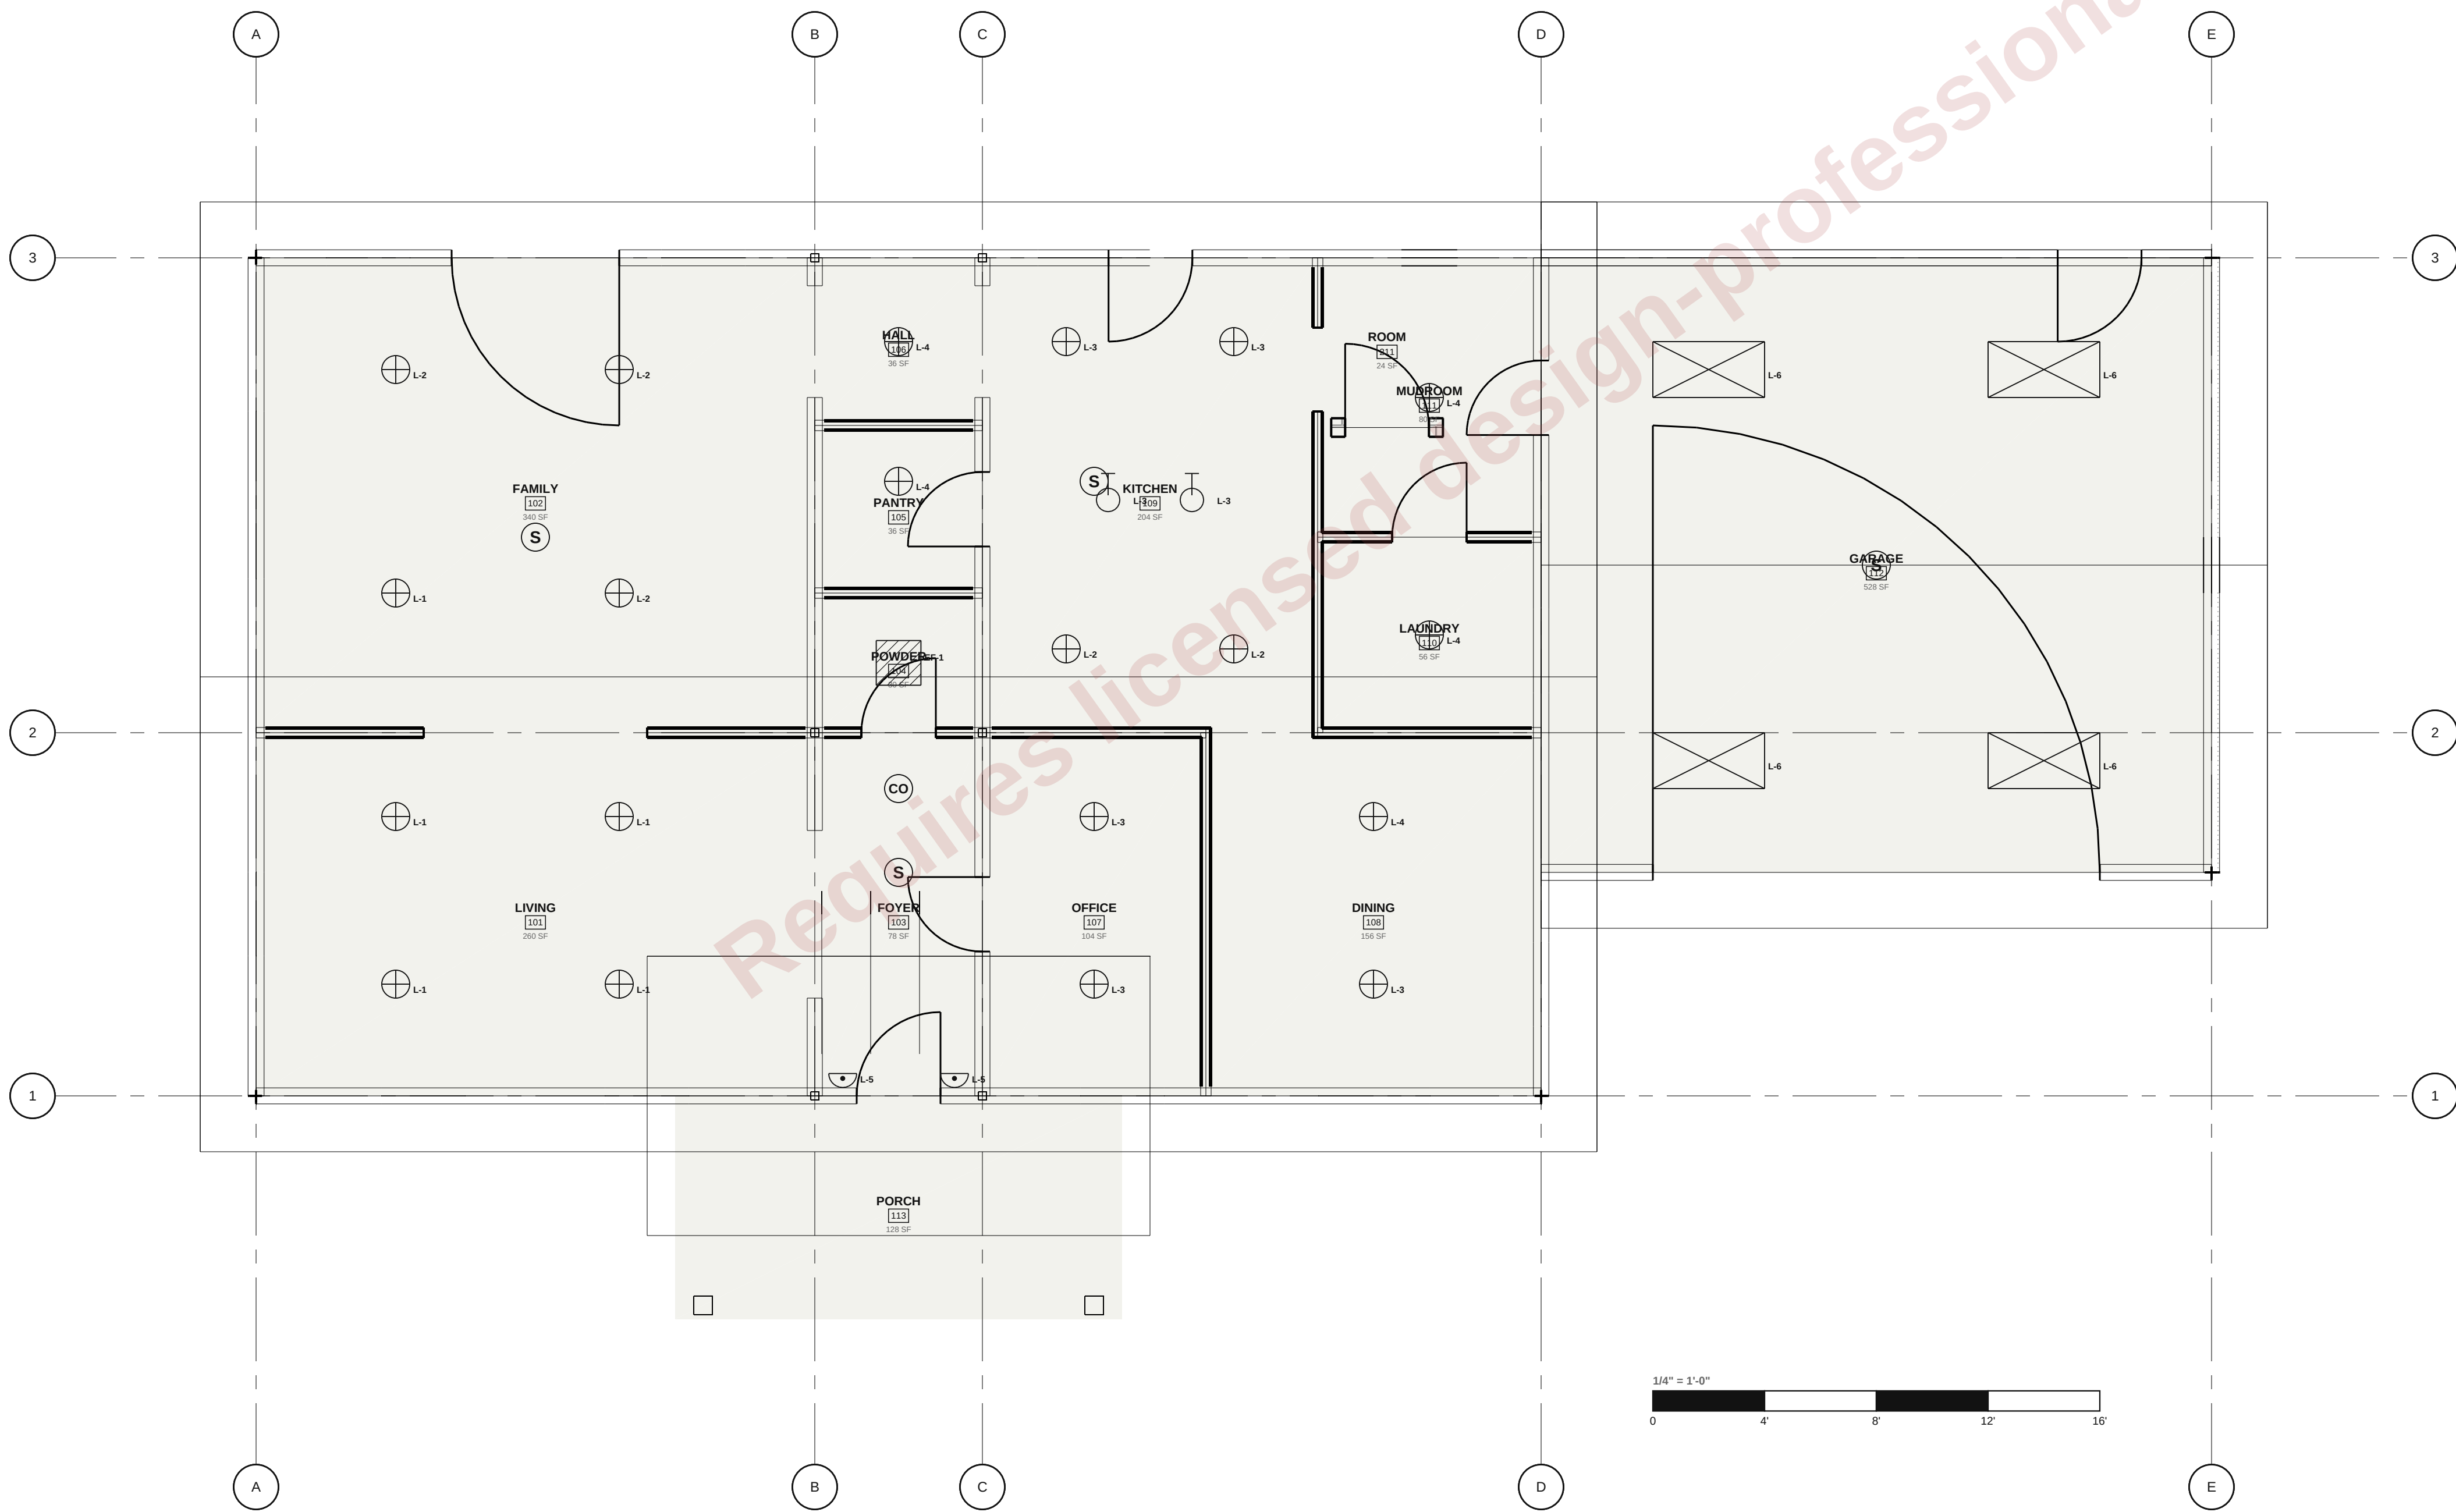

LIGHTING LEGEND

- A — 4" LED RECESSED DOWNLIGHT, 3000K
- B — PENDANT, OWNER-SELECTED
- C — WALL SCONCE
- D — 4" LED STRIP (GARAGE)
- SD / CO — SMOKE / CARBON MONOXIDE ALARM
- EF — EXHAUST FAN

LIGHTING NOTES

- ALL PERMANENT FIXTURES HIGH-EFFICACY (IECC R404.1), DIMMERS AT LIVING, DINING, KITCHEN, BEDROOMS.
- EXTERIOR: WALL LANTERNS AT ENTRY, GARAGE DOORS; MOTION FLOOD AT REAR; PHOTOCELL CONTROL.
- SWITCHING PER NEC 210.70 — SWITCH AT EACH ROOM ENTRANCE; 3-WAY AT STAIR (TOP & BOTTOM).